


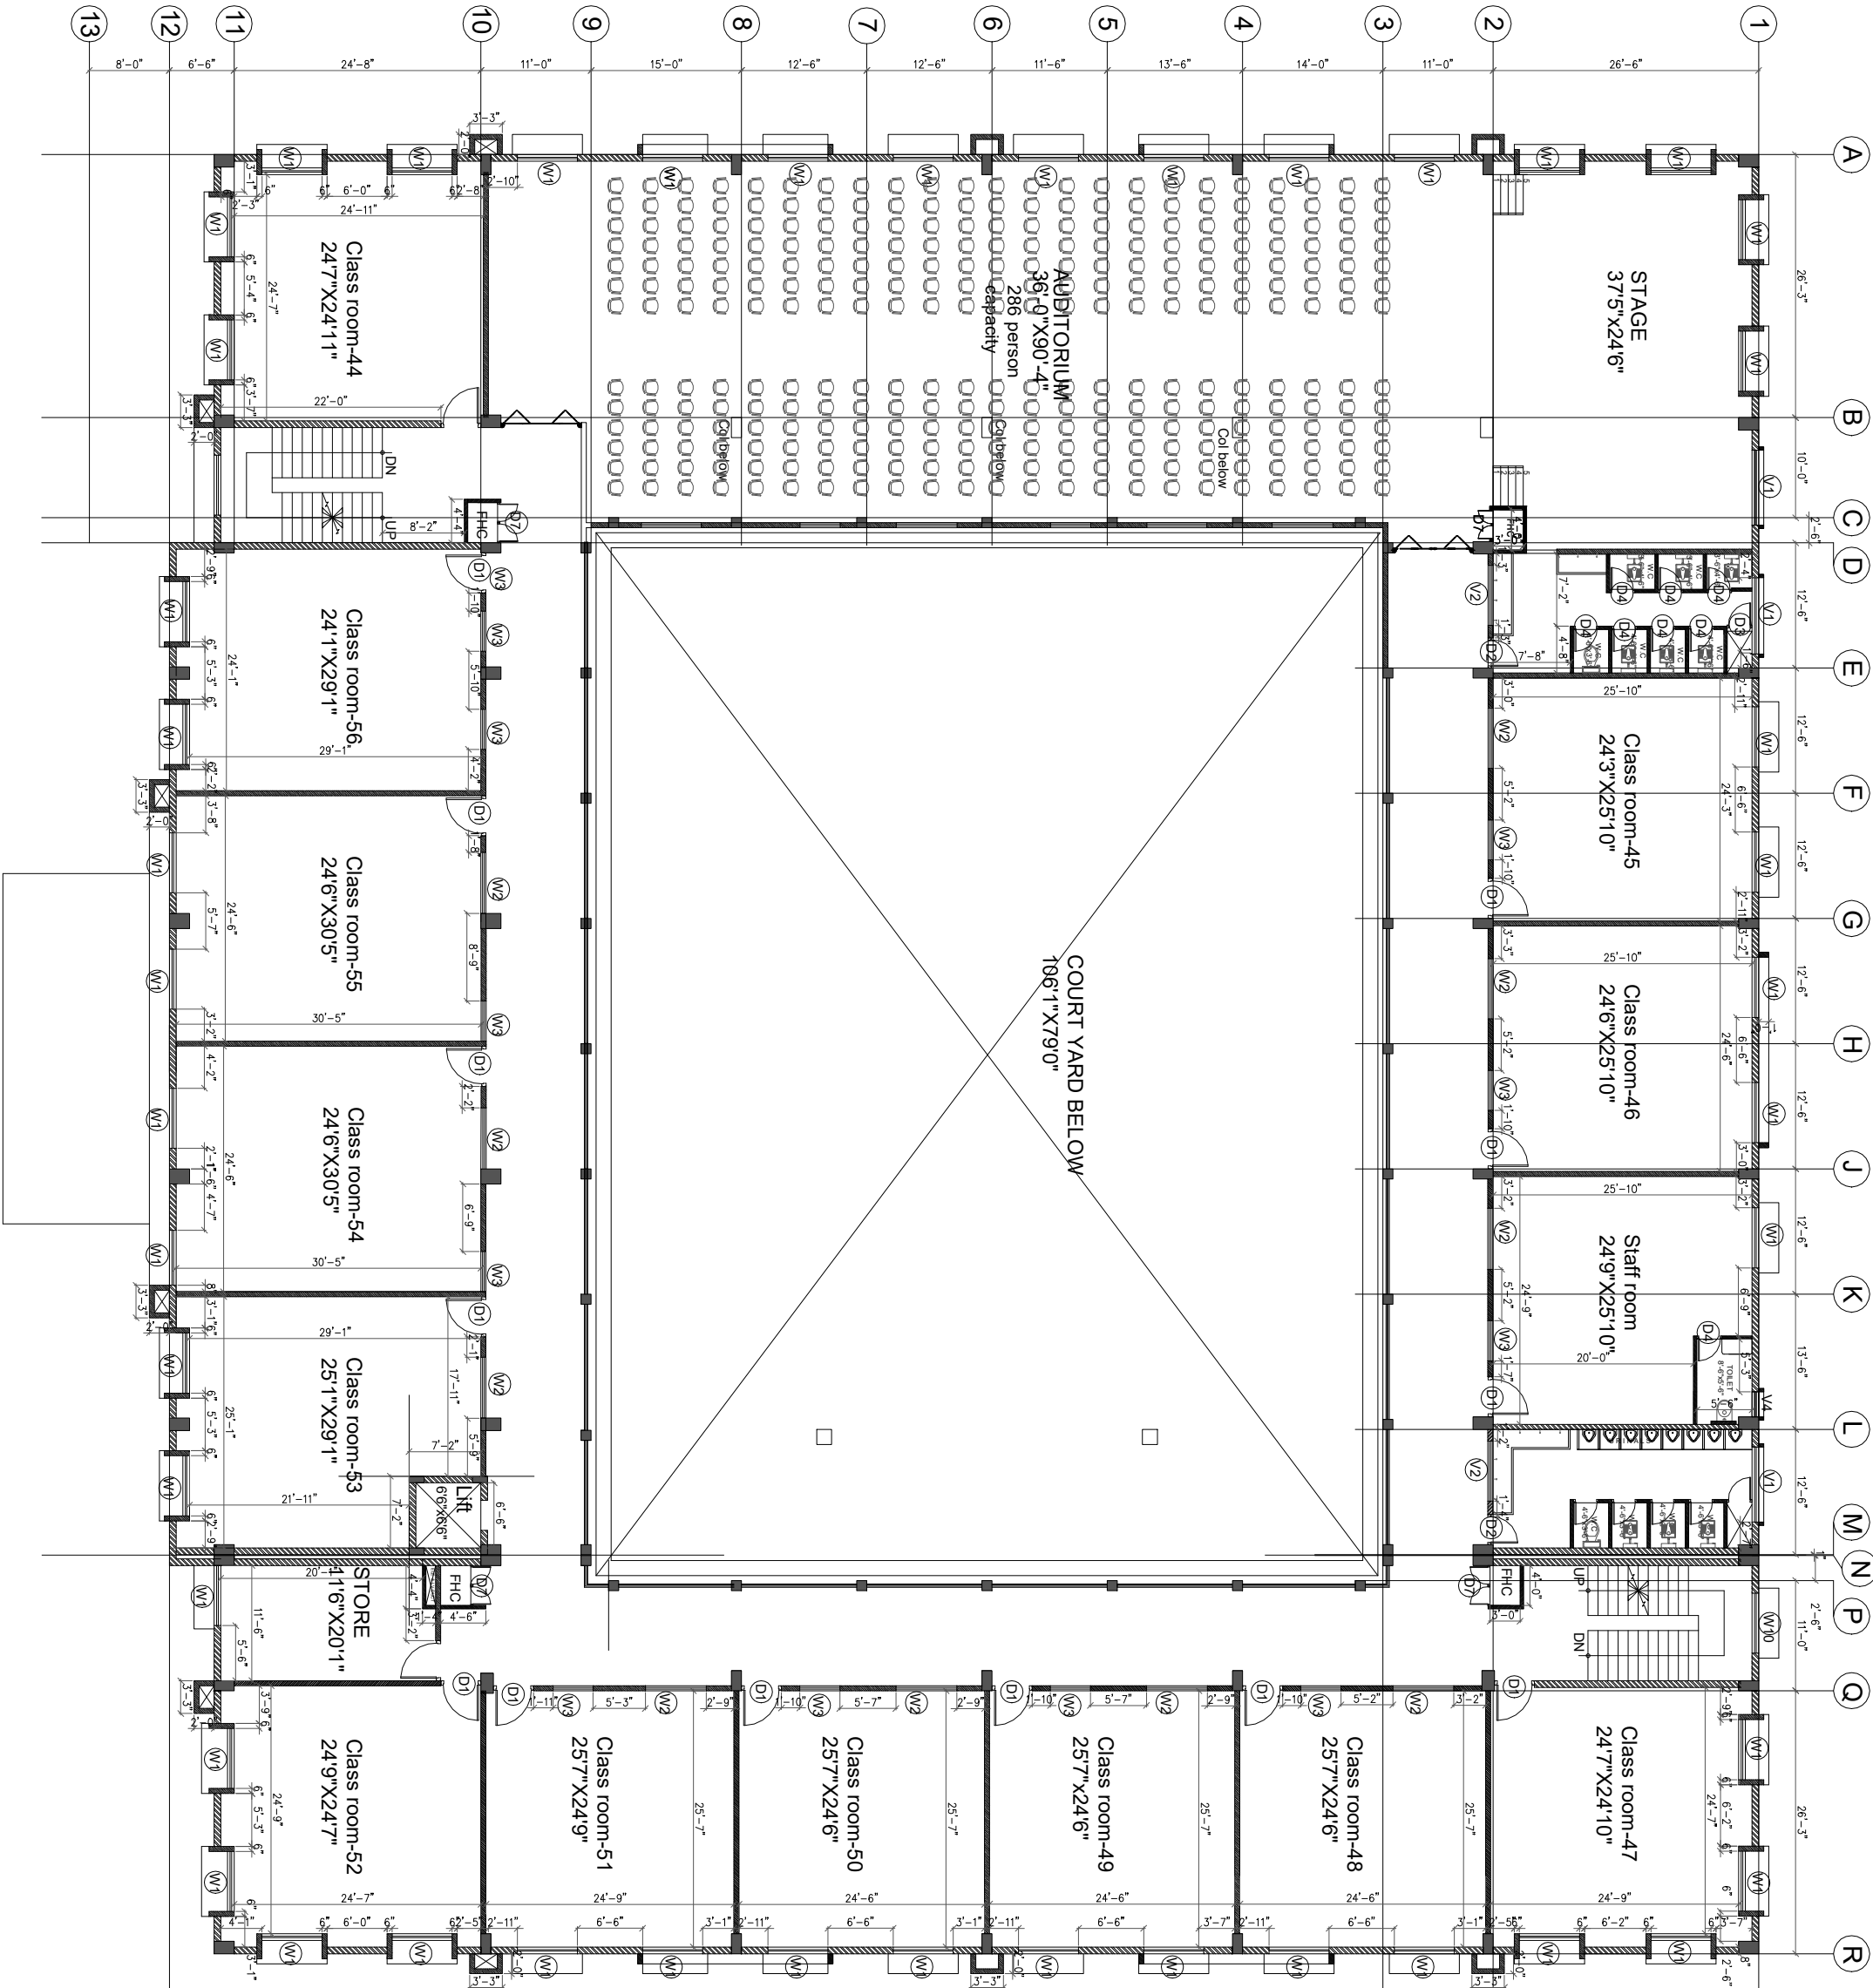

SCHEDULE OF OPENINGS (ALT HT FROM F.F.L.)
ALL DIMENSIONS ARE IN MM

WINDOW SCHEDULE			
SR NO.	TYPE	SIZE	SILL LVL, INT'L LVL, LOCATION
1	W1	6'-0"X10'-0"	Beam Bottom, Classroom
2	W1A	4'-0"X10'-0"	Beam Bottom, Classroom
3	W2	6'-0"X4'-0"	Beam Bottom, Corridor door
4	W3	4'-0"X4'-0"	Beam Bottom, Corridor door
5	W4	5'-0"X10'-0"	Beam Bottom, Staff Manager
6	W5	24'-0"X10'-0"	Beam Bottom, Staff Manager
7	W6	5'-0"X4'-0"	Beam Bottom, Restroom
8	W7	2'-0"X4'-0"	Beam Bottom, Restroom
9	W8	6'-0"X4'-0"	Beam Bottom, Restroom
10	W9	6'-0"X5'-0"	Beam Bottom, Restroom
11	W10	6'-0"X5'-0"	Beam Bottom, Restroom

VENTILATOR SCHEDULE			
SR NO.	TYPE	SIZE	SILL LVL, INT'L LVL, LOCATION
1	V1	7'-4"X5'-0"	Beam Bottom, Total
2	V2	6'-0"X4'-0"	Beam Bottom, Total
3	V3	4'-0"X4'-0"	Beam Bottom, Total
4	V4	2'-0"X4'-0"	Beam Bottom, Total
5	V5	2'-0"X4'-0"	Beam Bottom, Total
6	V6	2'-0"X4'-0"	Beam Bottom, Total
7	V7	1'-0"X3'-0"	Beam Bottom, Total

DOOR SCHEDULE			
SR NO.	TYPE	SIZE	SILL LVL, INT'L LVL, LOCATION
1	D1	4'-0"X7'-0"	Beam Bottom, Classroom
2	D2	3'-0"X7'-0"	Beam Bottom, Classroom
3	D3	2'-0"X7'-0"	Beam Bottom, Classroom
4	D4	2'-0"X7'-0"	Beam Bottom, Classroom
5	D5	2'-0"X7'-0"	Beam Bottom, Classroom
6	D6	2'-0"X7'-0"	Beam Bottom, Classroom
7	D7	4'-0"X4'-0"	Beam Bottom, Classroom

HATCH LEGEND

	8' thick wall
	6' thick wall
	4' thick wall
	7' deep sunk

R1	17-07-24	STAFF TOILET REVISED	THILAK
R0	06-07-24	GOOD FOR CONSTRUCTION	THILAK
REV	DATE	DESCRIPTION	DRAWN

RASHTROTTANA PARISHATH

PHE & FIRE CONSULTANT:

PHE & FIRE CONSULTANT:
MEP Engg Services
#72, 6th Main road, 2nd Stage, A Block,
RHCOS Layout, Bengaluru-56.
Email: info@phefire.com
Website: www.phefire.com

ELECTRICAL CONSULTANT:

ELECTRICAL CONSULTANT:
Skyline electro
#17, Annapurna Nagar, 1st Stage, A Block,
Bengaluru - 560 012
Email: info@skylineelectro.com
Website: www.skylineelectro.com

STRUCTURAL CONSULTANT:

STRUCTURAL CONSULTANT:
PERISTYLE
#27/44-1, 1st Floor, 1st Stage, A Block,
Bengaluru - 560 010
Email: info@peristyle.com
Website: www.peristyle.com

GOOD FOR CONSTRUCTION

ARCHITECT: MYSORE CONSULTANTS PVT.LTD.

ARCHITECT:
MYSORE CONSULTANTS PVT.LTD.
143, 5th Floor, Annex Building,
Bangalore-560001
Tel: 080-22211753, Website: www.mysoreconsultants.com

RASHTROTTANA VIDYA KENDRA,
AT HANGAL, HAVERI DISTRICT.

Third floor plan(phase-2)

RESUME:

SCALE:	DATE: 20/02/2020	JOB No.
DEALT TIME:	CHECKED: ASD	
DRAWING NO:	B1-A-2003	REVNO